





## Appendix C

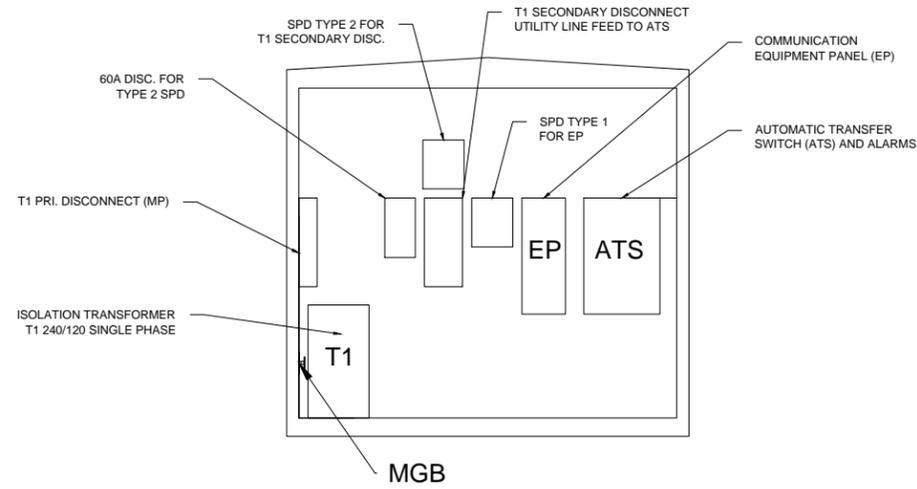


**ELEVATION**  
**ELECTRICAL DISTRIBUTION LAYOUT**  
 SCALE: 1"=2.5'

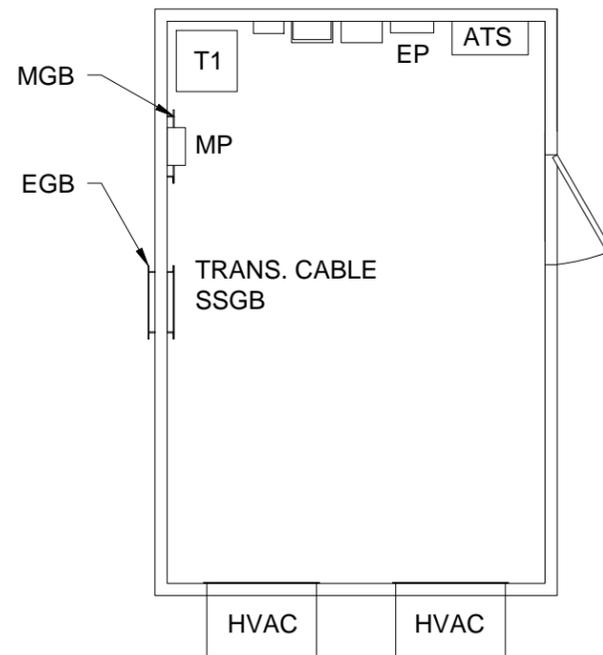

**TOP VIEW**  
**ELECTRICAL DISTRIBUTION LAYOUT**  
 SCALE: 1"=2.5'

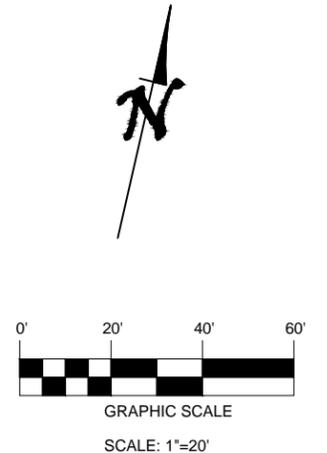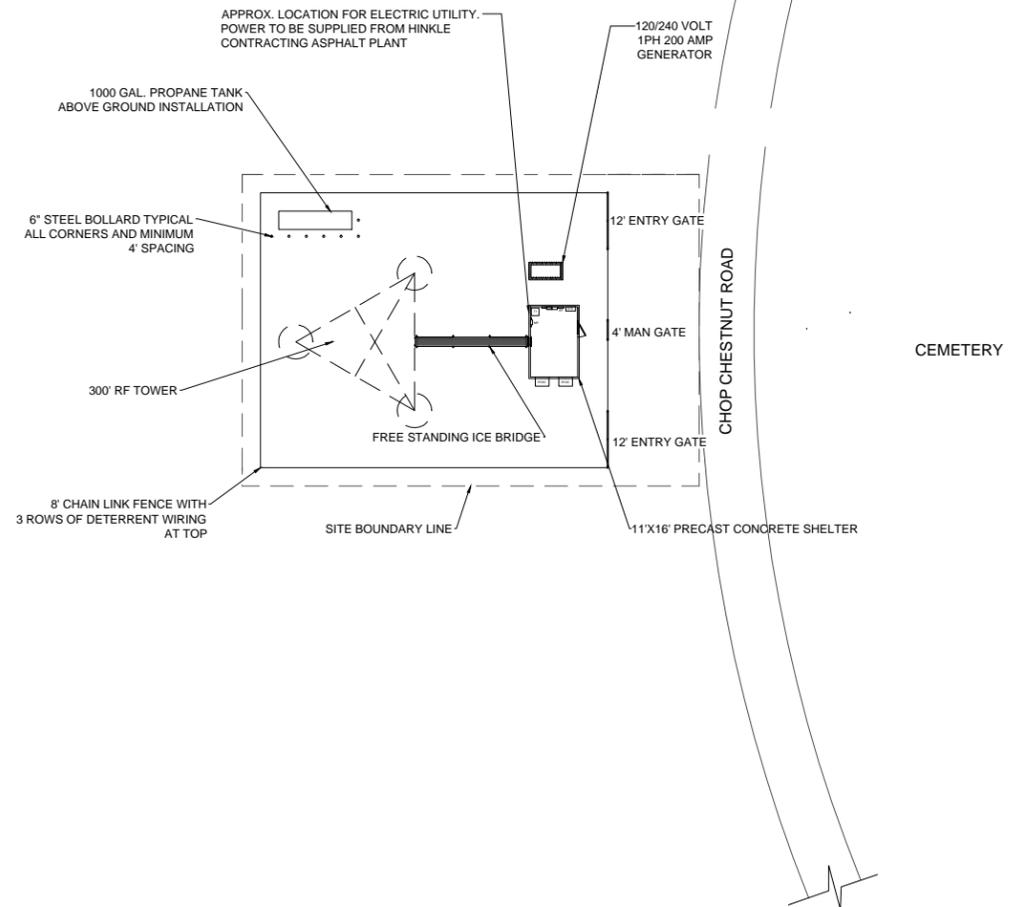

MISSION CRITICAL PARTNERS 200 INNOVATION BLVD. STATE COLLEGE, PA 16803 O:888.862.8640 F:814.217.6807 www.MCP911.com	<b>POWELL COUNTY KENTUCKY COMMUNICATIONS SUPPORT</b> <b>HINKLE TOWER SITE DEVELOPMENT</b>			<b>REVISIONS</b>		<b>DRAWING TITLE</b>	
	REV	DESCRIPTION	DATE			HINKLE TOWER SITE AND ELEVATION PLAN	
						<b>DRAWING NUMBER</b> <b>PW06-T100</b>	
						<b>DATE:</b> 3/17/2013	
						<b>DESIGNED BY:</b> JPK <b>DRAWN BY:</b> JPK <b>CHECKED BY:</b> XXX	
POWELL COUNTY, KENTUCKY <b>HINKLE TOWER SITE PLAN</b> PROJECT # 12-140							

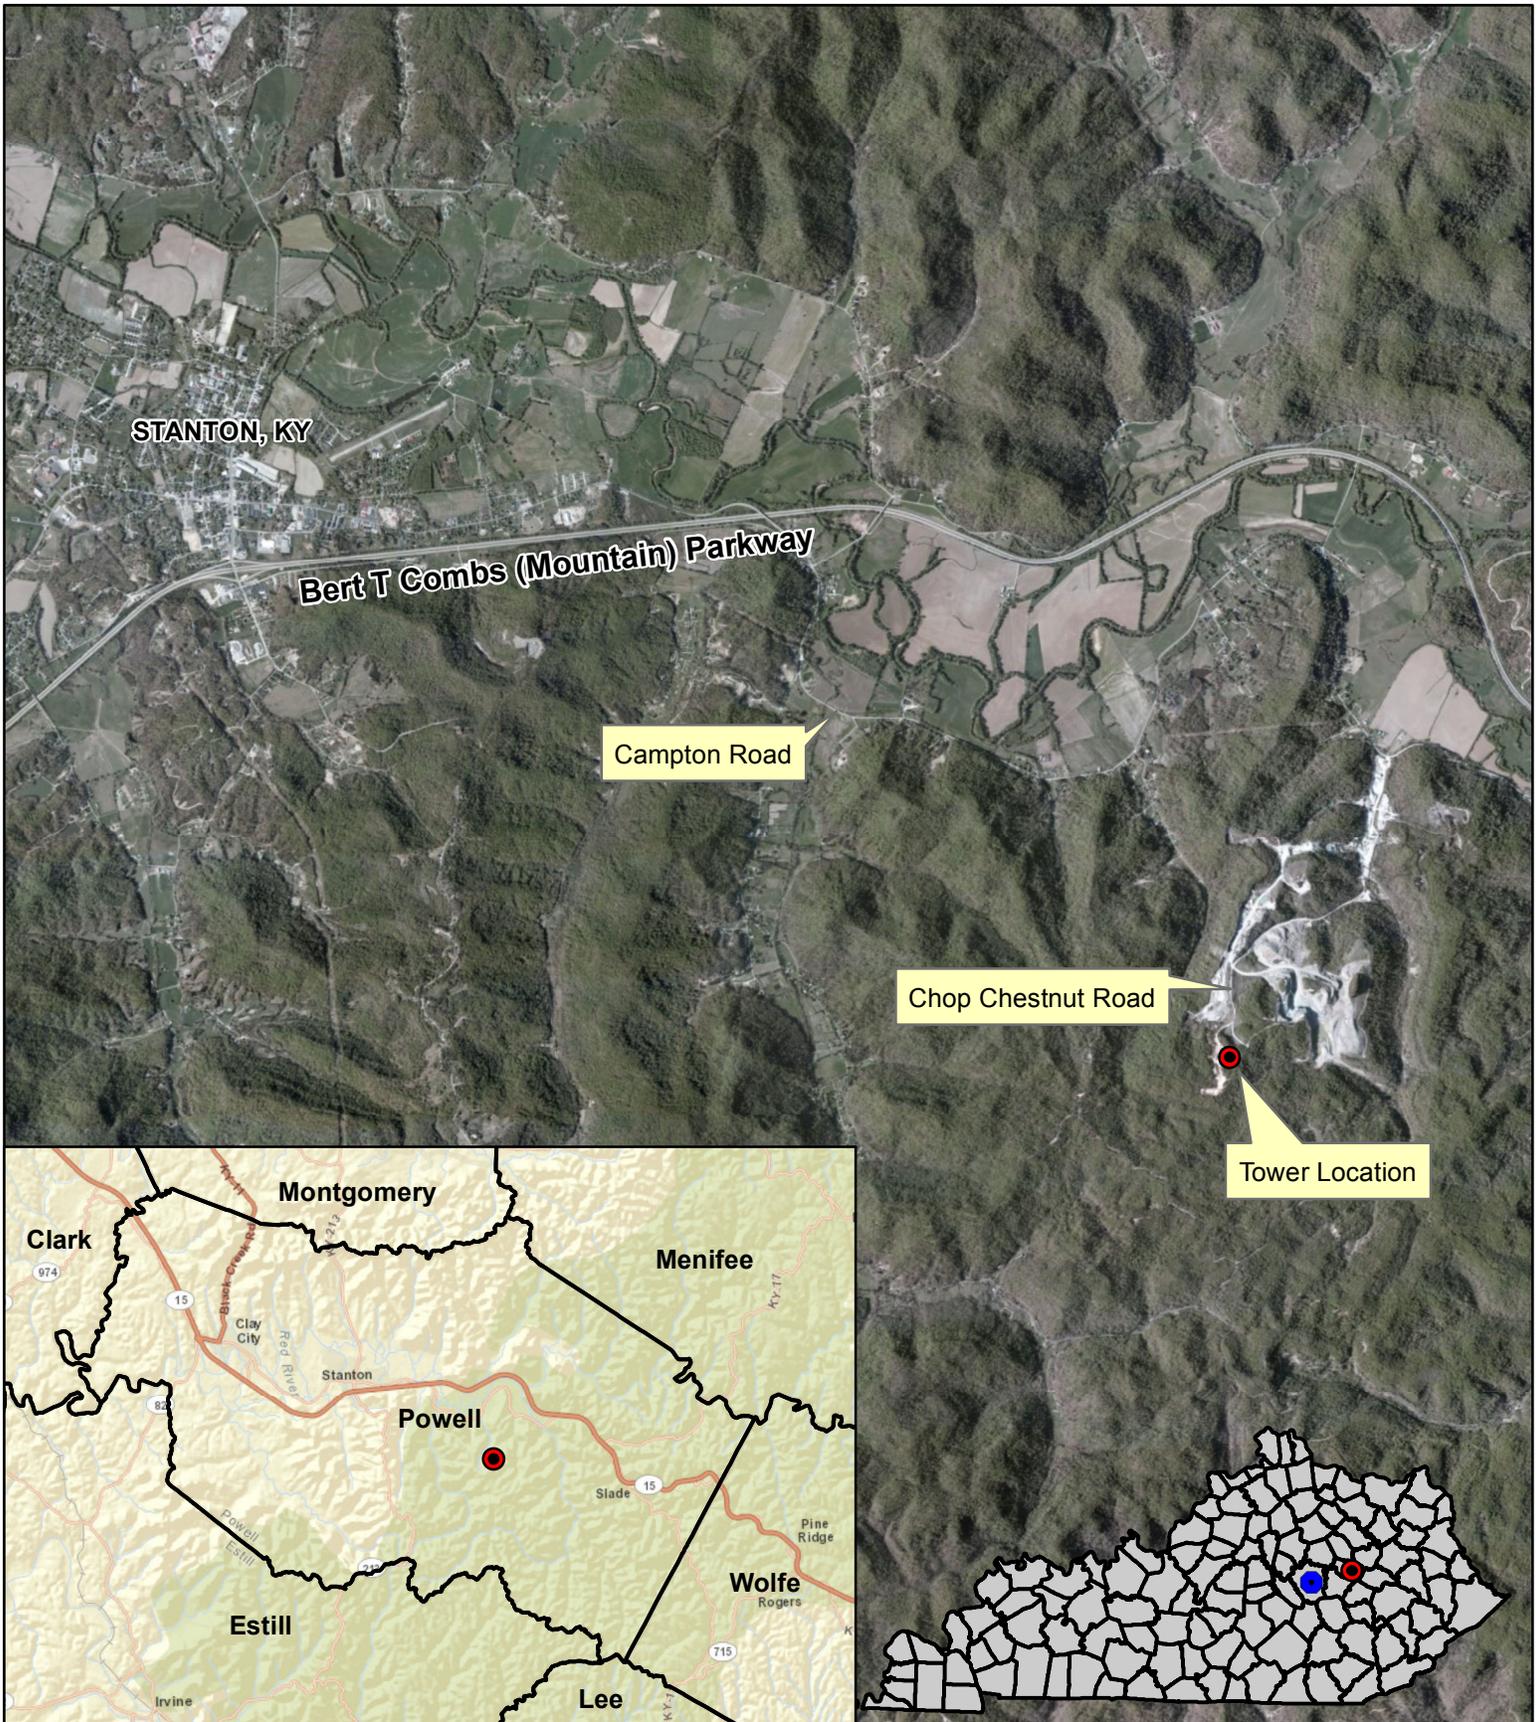

**Legend**

- Tower Location
- Blue Grass Army Depot



**Figure 2**

**Powell County Emergency  
Communication Tower  
Location**

**7245 Campton Road  
Stanton, KY 40380**



**Legend**



Tower Location



250 125 0 250 500



1"=500'

**Figure 2A**

**Powell County Emergency  
Communication Tower  
Location**

**7245 Campton Road  
Stanton, KY 40380**